



SECTION Y-Y
SCALE 1:100





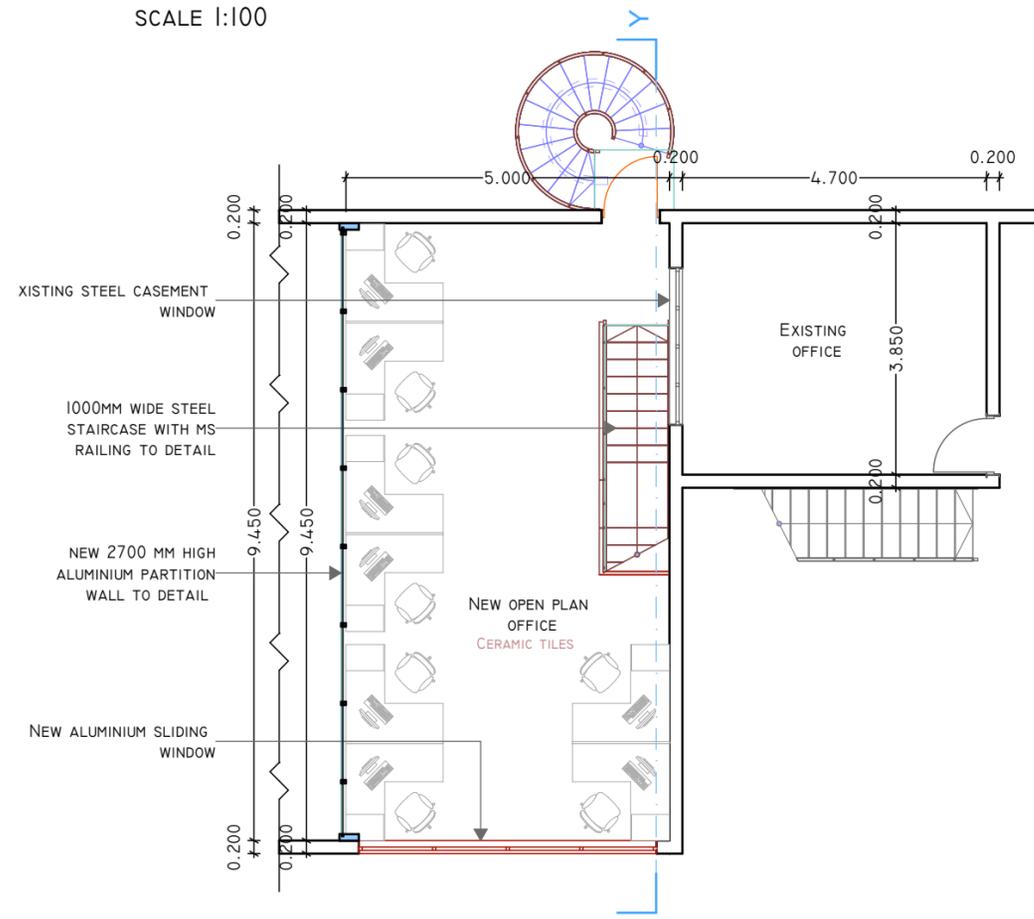


MEZZANINE FLOOR PLAN
SCALE 1:100

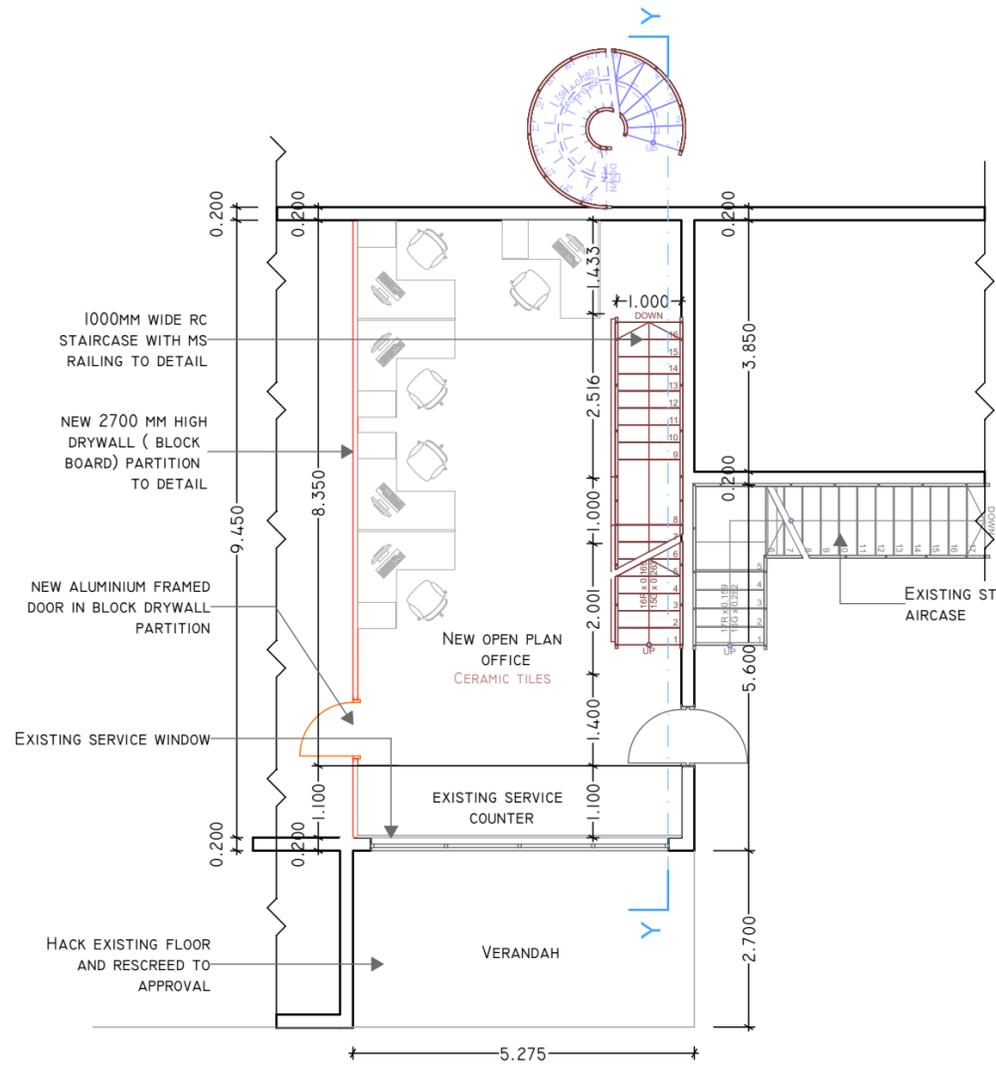

GROUND FLOOR PLAN

SIGN OFF				PROJECT	DRAWING		DRAWING NO.1 KENYA POWER
ITEM	DESIGNATION	SIGN	DATE				
APPROVED BY:	CHIEF ENGINEER FLEET MANAGEMENT			PROPOSED MEZZANINE OFFICE SPACE LOCATION: RUARAKA DEPOT	FLOOR PLAN & SECTIONS		DRAWING NO.1 KENYA POWER
RECOMMENDED BY:	PRINCIPAL PROJECTS OFFICER						
CHECKED BY:	ADMIN OFFICER NAIROBI REGION						
DRAWN BY:	SENIOR TECHNICIAN NAIROBI REGION						

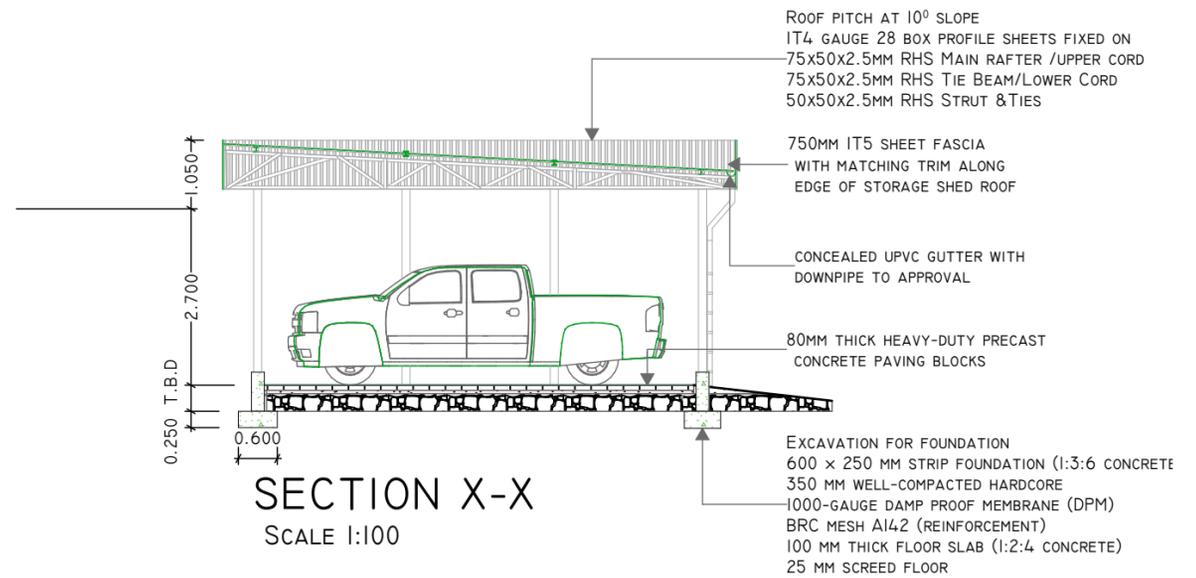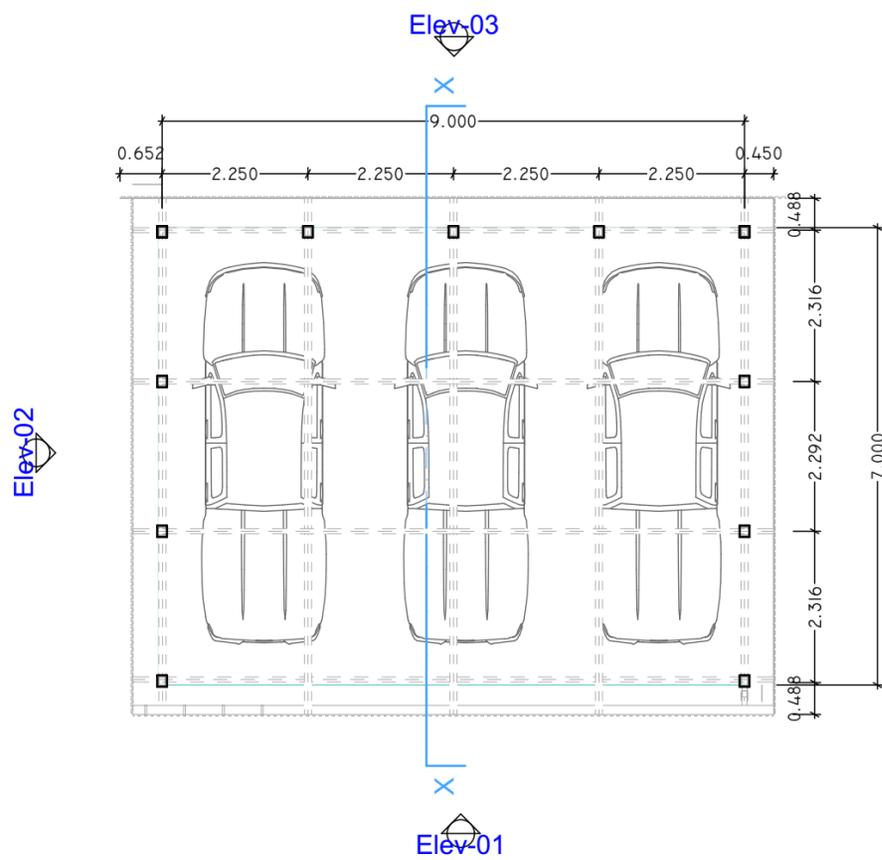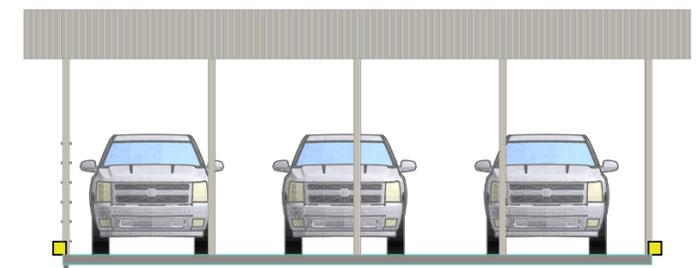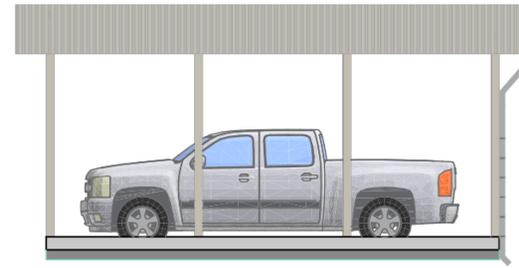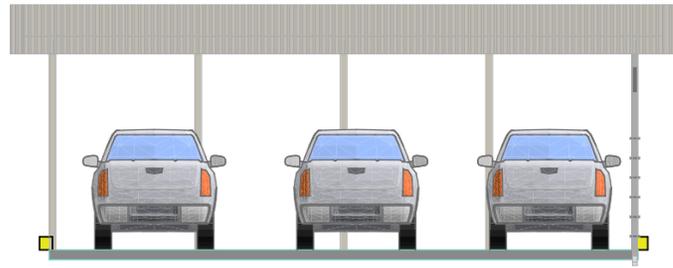

CARWASH SHED PLAN
SCALE 1:100

SIGN OFF				PROJECT	DRAWING		DRAWING NO.1 KENYA POWER				
ITEM	DESIGNATION	SIGN	DATE								
APPROVED BY:	CHIEF ENGINEER FLEET MANAGEMENT							PROPOSED MEZZANINE OFFICE SPACE LOCATION: RUARAKA DEPOT	FLOOR PLAN & SECTIONS		
RECOMMENDED BY:	PRINCIPAL PROJECTS OFFICER										
CHECKED BY:	ADMIN OFFICER NAIROBI REGION										
DRAWN BY:	SENIOR TECHNICIAN NAIROBI REGION										